


1 2 3 4 5 6

A B C D E N

A B C D

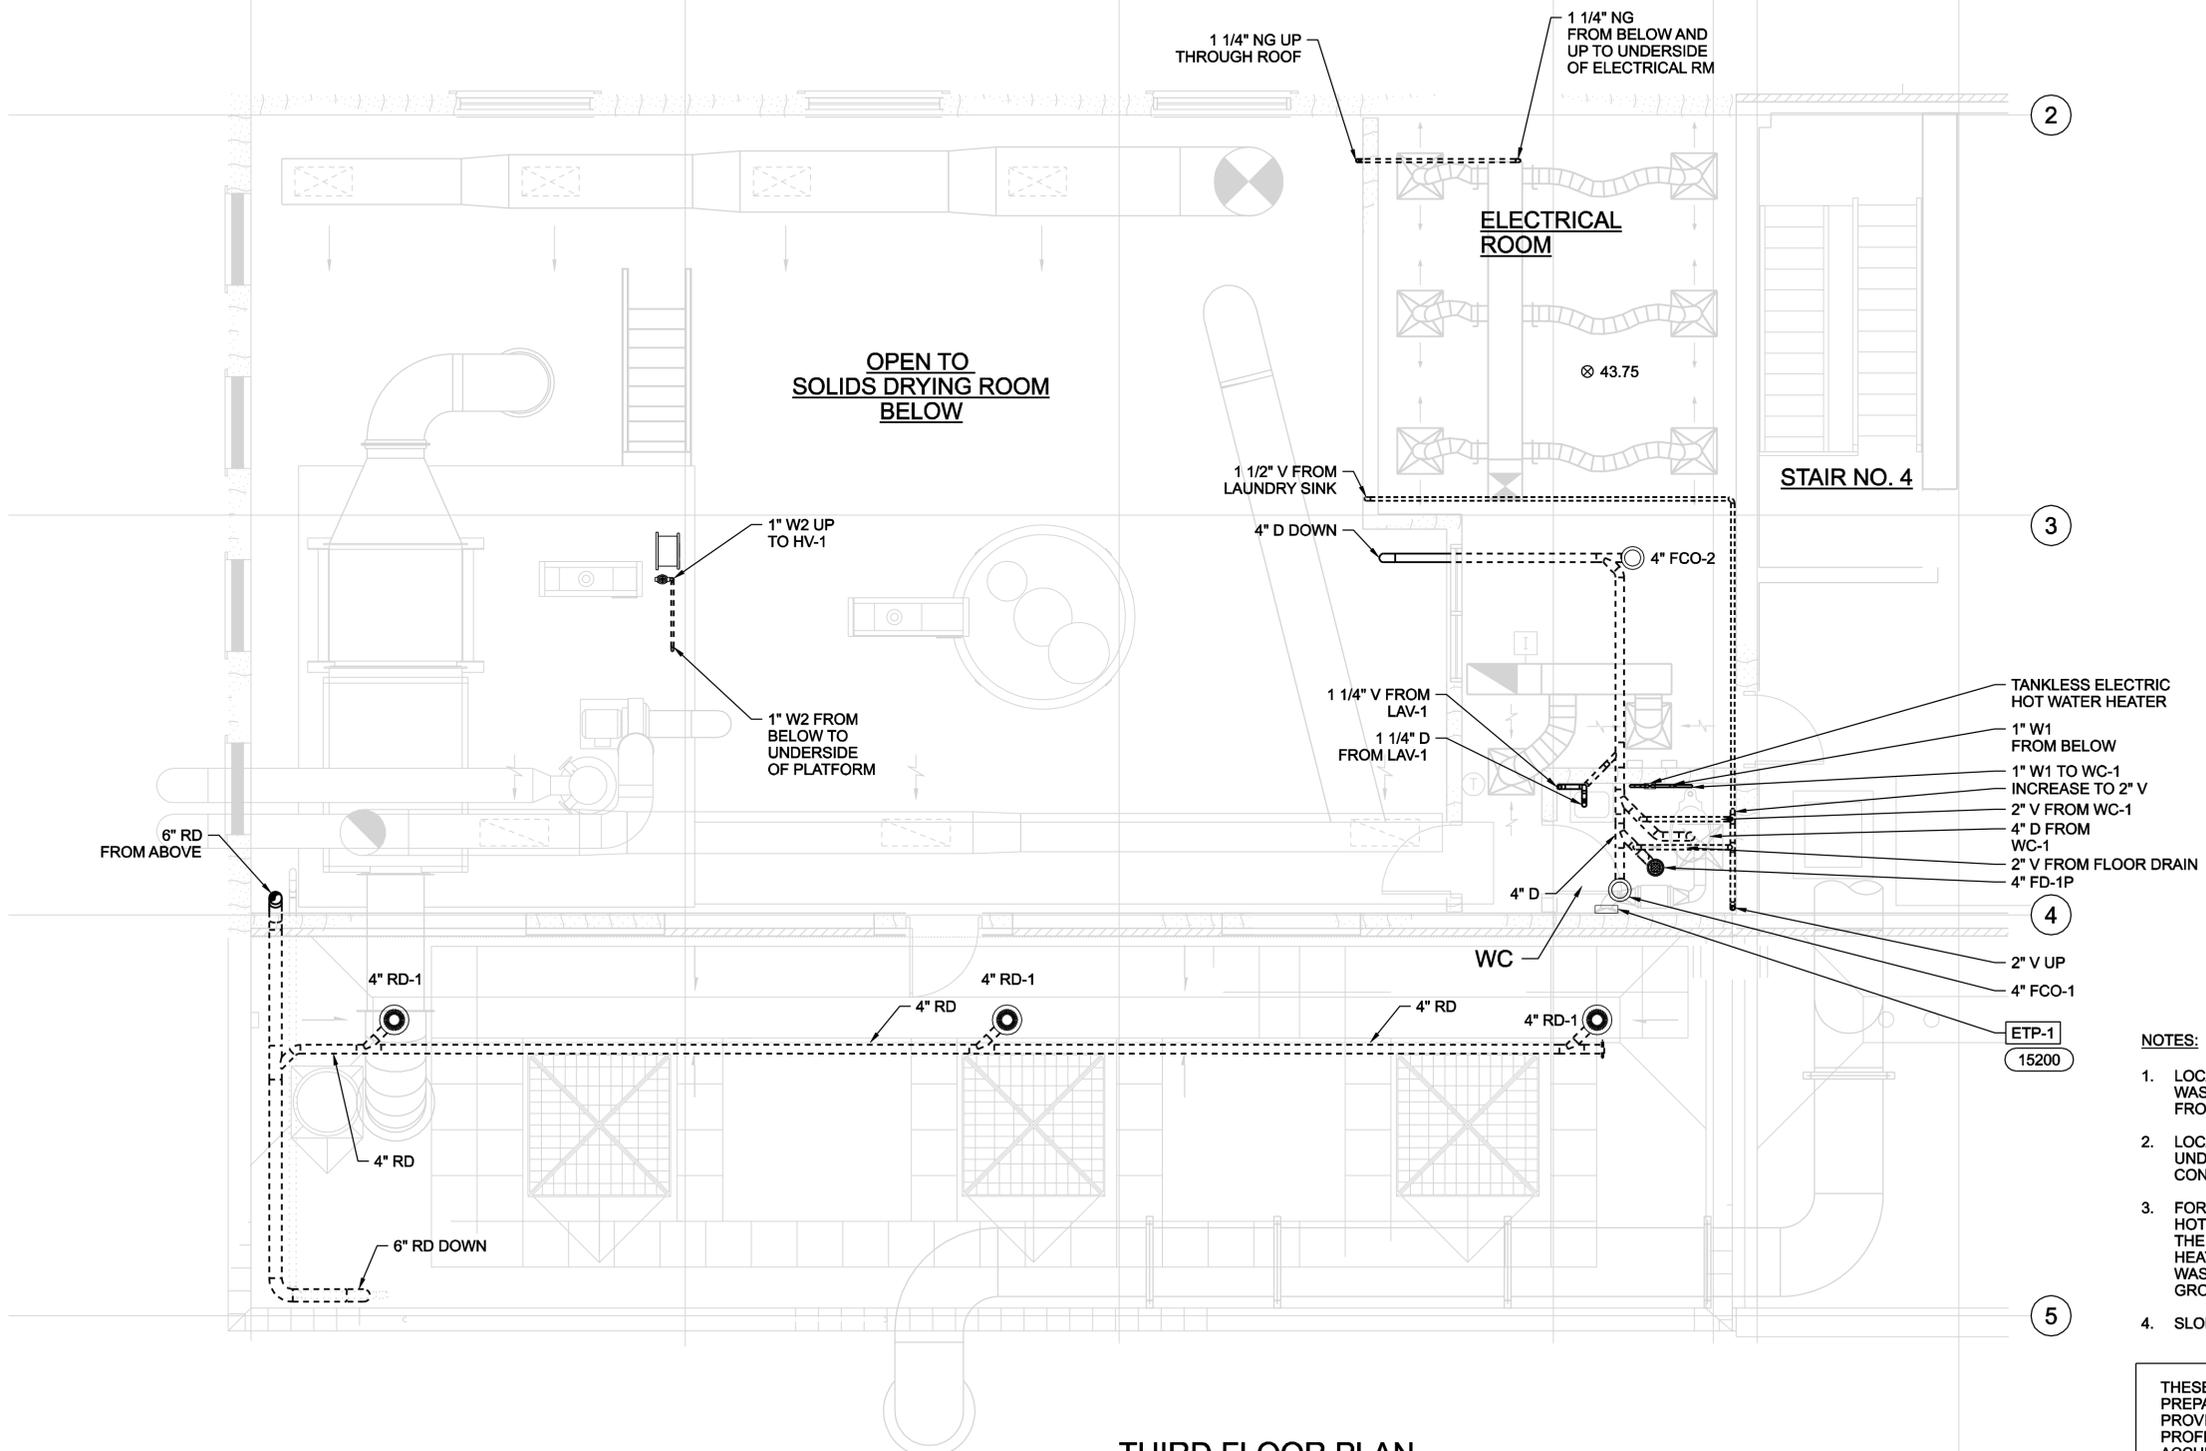

THIRD FLOOR PLAN
1/4"=1'-0"

- NOTES:**
- LOCATE ETP-1 TRAP PRIMING VALVE IN WASHROOM, WITH 1/2" CONNECTION FROM W2 WATER SUPPLY ON GROUND FLOOR.
 - LOCATE TANKLESS HOT WATER HEATER UNDER LAVATORY, WITH 3/4" W1 AND 3/4" HW CONNECTIONS TO LAVATORY.
 - FOR THE PURPOSE OF DRAWING CLARITY, HOT WATER PIPING IS NOT SHOWN. FROM THE OUTLET OF THE TANKLESS HOT WATER HEATER, ROUTE 3/4" HW TO LAV-1 IN WASHROOM AND LAUNDRY SINK ON GROUND FLOOR.
 - SLOPE ROOF DRAINAGE LINES AT 1%.

THESE RECORD DOCUMENTS HAVE BEEN PREPARED BASED ON THE INFORMATION PROVIDED BY OTHERS. THE DESIGN PROFESSIONAL HAS NOT VERIFIED THE ACCURACY AND/OR COMPLETENESS OF THIS INFORMATION AND SHALL NOT BE RESPONSIBLE FOR ANY ERRORS OR OMISSIONS WHICH MAY BE INCORPORATED HEREIN AS A RESULT.

RECORD DRAWING RE-ISSUED FOR CONSTRUCTION ISSUED FOR CONSTRUCTION FOR FINAL REVIEW/ BUILDING PERMIT		DR S LAROCQUE M RAHMAN B GACKSTATTER	
01/20/08	09/08/06	07/04/06	06/05/06
3	2	1	0
NO.	DATE	NO.	DATE
DSGN	S LAROCQUE	CHK	M RAHMAN
DR	S LAROCQUE	BY	B GACKSTATTER
APVD	S LAROCQUE	BY	B GACKSTATTER
STAMFORD WATER POLLUTION CONTROL AUTHORITY SOLIDS DRYING PROJECT		BUILDING SERVICES PLUMBING THIRD FLOOR PLAN	
VERIFY SCALE BAR IS ONE INCH ON ORIGINAL DRAWING.			
DATE	JUNE 2006	PROJ	334058
DWG	B-2411	SHEET	B13

REUSE OF DOCUMENTS: THIS DOCUMENT AND THE IDEAS AND DESIGNS INCORPORATED HEREIN, AS AN INSTRUMENT OF PROFESSIONAL SERVICE, IS THE PROPERTY OF CH2M HILL AND IS NOT TO BE USED, IN WHOLE OR IN PART, FOR ANY OTHER PROJECT WITHOUT THE WRITTEN AUTHORIZATION OF CH2M HILL. © CH2M HILL 2004. ALL RIGHTS RESERVED.